

# BASEMENT FLOOR PLAN

- General Notes**
- DRAWINGS ARE THE COPYRIGHT PROPERTY OF INI DESIGN STUDIO. THE DRAWINGS AND SPECIFICATIONS FOR THIS PROJECT ARE PROTECTED BY COPYRIGHT AND WILL NOT BE REPRODUCED, USED, OR DISTRIBUTED WITHOUT EXPRESS WRITTEN PERMISSION OF INI DESIGN STUDIO.
  - THESE DRAWINGS INDICATE IN GENERAL THE PROJECT IN TERMS OF BUILDING DESIGN CONCEPTS, THE DIMENSIONS OF THE BUILDINGS AND THE MAJOR BUILDING DESIGN ELEMENTS. AS INDICATED OR SPECIFIED, THE CONTRACTOR SHALL FINISH ALL ITEMS REQUIRED FOR THE PROPER EXECUTION AND COMPLETION OF THE WORKS. DECISIONS OF THE INI AS TO THE ITEMS OF WORK INCLUDED WITHIN THE DOCUMENT SHALL BE FINAL AND BINDING ON THE CONTRACTOR.
  - ALL DIMENSIONS ARE IN MILLIMETERS, UNLESS OTHERWISE MENTIONED/SPECIFIED.
  - DRAWINGS IN NO CASE SHALL BE SCALED AND ONLY WRITTEN DIMENSIONS SHALL BE FOLLOWED. LARGE SCALE DETAILS SHALL TAKE PRECEDENCE OVER SMALL SCALE DRAWINGS.
  - PARTITIONS AND WALLS SHOWN CENTERED ON COLUMN CENTER OR FLUSH-FACED WITH STRUCTURAL COLUMNS ARE NOT DIMENSIONED.
  - CONTRACTOR SHALL INFORM AND OBTAIN PERMISSION IN WRITING FROM THE INI BEFORE MAKING ANY DEVIATIONS FROM THE DRAWINGS.
  - ITEMS OF WORK REQUIRED ON ONE DRAWING OR IN ONE SECTION OF THE SPECIFICATIONS HAVE THE SAME FORCE AND EFFECT AS IF REQUIRED IN ALL DRAWINGS, OR IN ALL SECTIONS OF THE SPECIFICATIONS.
  - PLINTH LEVELS TO BE DECIDED ON SITE WITH REFERENCE TO LEVELS ON THE SITE IN CONSULTATION WITH BUILDING DESIGN DRAWINGS.
  - FOR DOOR AND WINDOWS SCHEDULE REFER DRAWING NO. \_\_\_\_\_
  - FOR DOOR AND WINDOWS SCHEDULE REFER DRAWING NO. \_\_\_\_\_
  - RAIN WATER DRAIN PIPES OR SLEEVES THROUGH BEAMS AND CURBING TO BE INSTALLED WHILE CASTING AS PER THE POSITIONS SHOWN.
  - FOR DIMENSIONS, LOCATIONS AND DETAILS OF ALL STRUCTURAL MEMBERS REFER STRUCTURAL DRAWINGS.
  - DIMENSIONS ON ALL ELEVATIONS AND SECTIONS SHOWN ON BUILDING DESIGN DRAWINGS ARE SHOWN AS TOP OF UN-FINISHED FLOOR LEVEL UNLESS OTHERWISE MENTIONED.
  - ALL DRAWINGS SHALL BE READ IN CONJUNCTION WITH ALL OTHER CONSULTANTS' DRAWINGS, TOGETHER WITH THE SPECIFICATIONS. DISCREPANCIES AND/OR AMBIGUITIES, IF ANY, SHALL BE BROUGHT TO THE NOTICE OF THE INI AND CLARIFICATIONS SHALL BE MADE PRIOR TO EXECUTION. SCPL'S DECISION IN THIS REGARD SHALL BE FINAL AND BINDING.
  - THE CONTRACTOR SHALL COORDINATE ALL MECHANICAL FLOOR AND WALL SLEEVES AND SHAFTS IN CONCRETE SLABS AND WALLS WITH MECHANICAL, PLUMBING, FIRE PROTECTION, ELECTRICAL, STRUCTURAL AND BUILDING DESIGN DRAWINGS.
  - NOTES APPEARING ON VARIOUS DRAWINGS FOR DIFFERENT SYSTEMS AND MATERIAL SHEET SHALL BE REVIEWED AND NOTES ON ANY ONE DRAWING SHALL BE APPLIED TO RELATED DRAWINGS AND DETAILS.

LEGEND	
	450mm WIDE STORM WATER DRAIN CHANNEL WITH GRATINGS SLOPE 1:300
	FLOW DIRECTION
	STORM DRAIN SUMP PUMPING LINE
	STORM DRAIN PIPE
	DRAIN LINE
	PUMP ROOM SUMP PUMPING LINE
	PUMP ROOM SUMP PIPE
	SEWERAGE SUMP PUMP DRAINAGE PIPE
	SEWERAGE PIPE
	450x450mm CATCH BASIN
	DOMESTIC WATER SUPPLY
	FLUSH TANK
	BBS COCK WITH HEALTH FAUCET
	BALL VALVE
	ANGLE COCK
	IRRIGATION WATER SUPPLY
	GARDEN HYDRANT
	WASTE PIPE
	SOIL PIPE
	SOIL STACK
	WASTE STACK
	N/HH TRAP
	FLOOR DRAIN

Rev	Purpose of Issue	Date	Authorized

TENDER DRAWINGS

Key Plan

Project : SANSKAR KENDRA PLAZA

Client : SRFDCL

Design Consultant : INI DESIGN STUDIO

Structural Consultant :


Project : INI Project no : 124200580

Drawing Title : PLUMBING LAYOUT FOR BASEMENT FLOORING LEVEL PLAN

Original Scale : Drawn By : KK Checked By : NT Authorized By : NT Size : A2

Date : 05.12.2025 Date : 05.12.2025 Date : 05.12.2025

Drawing Number : PL-BAS-01 Rev :

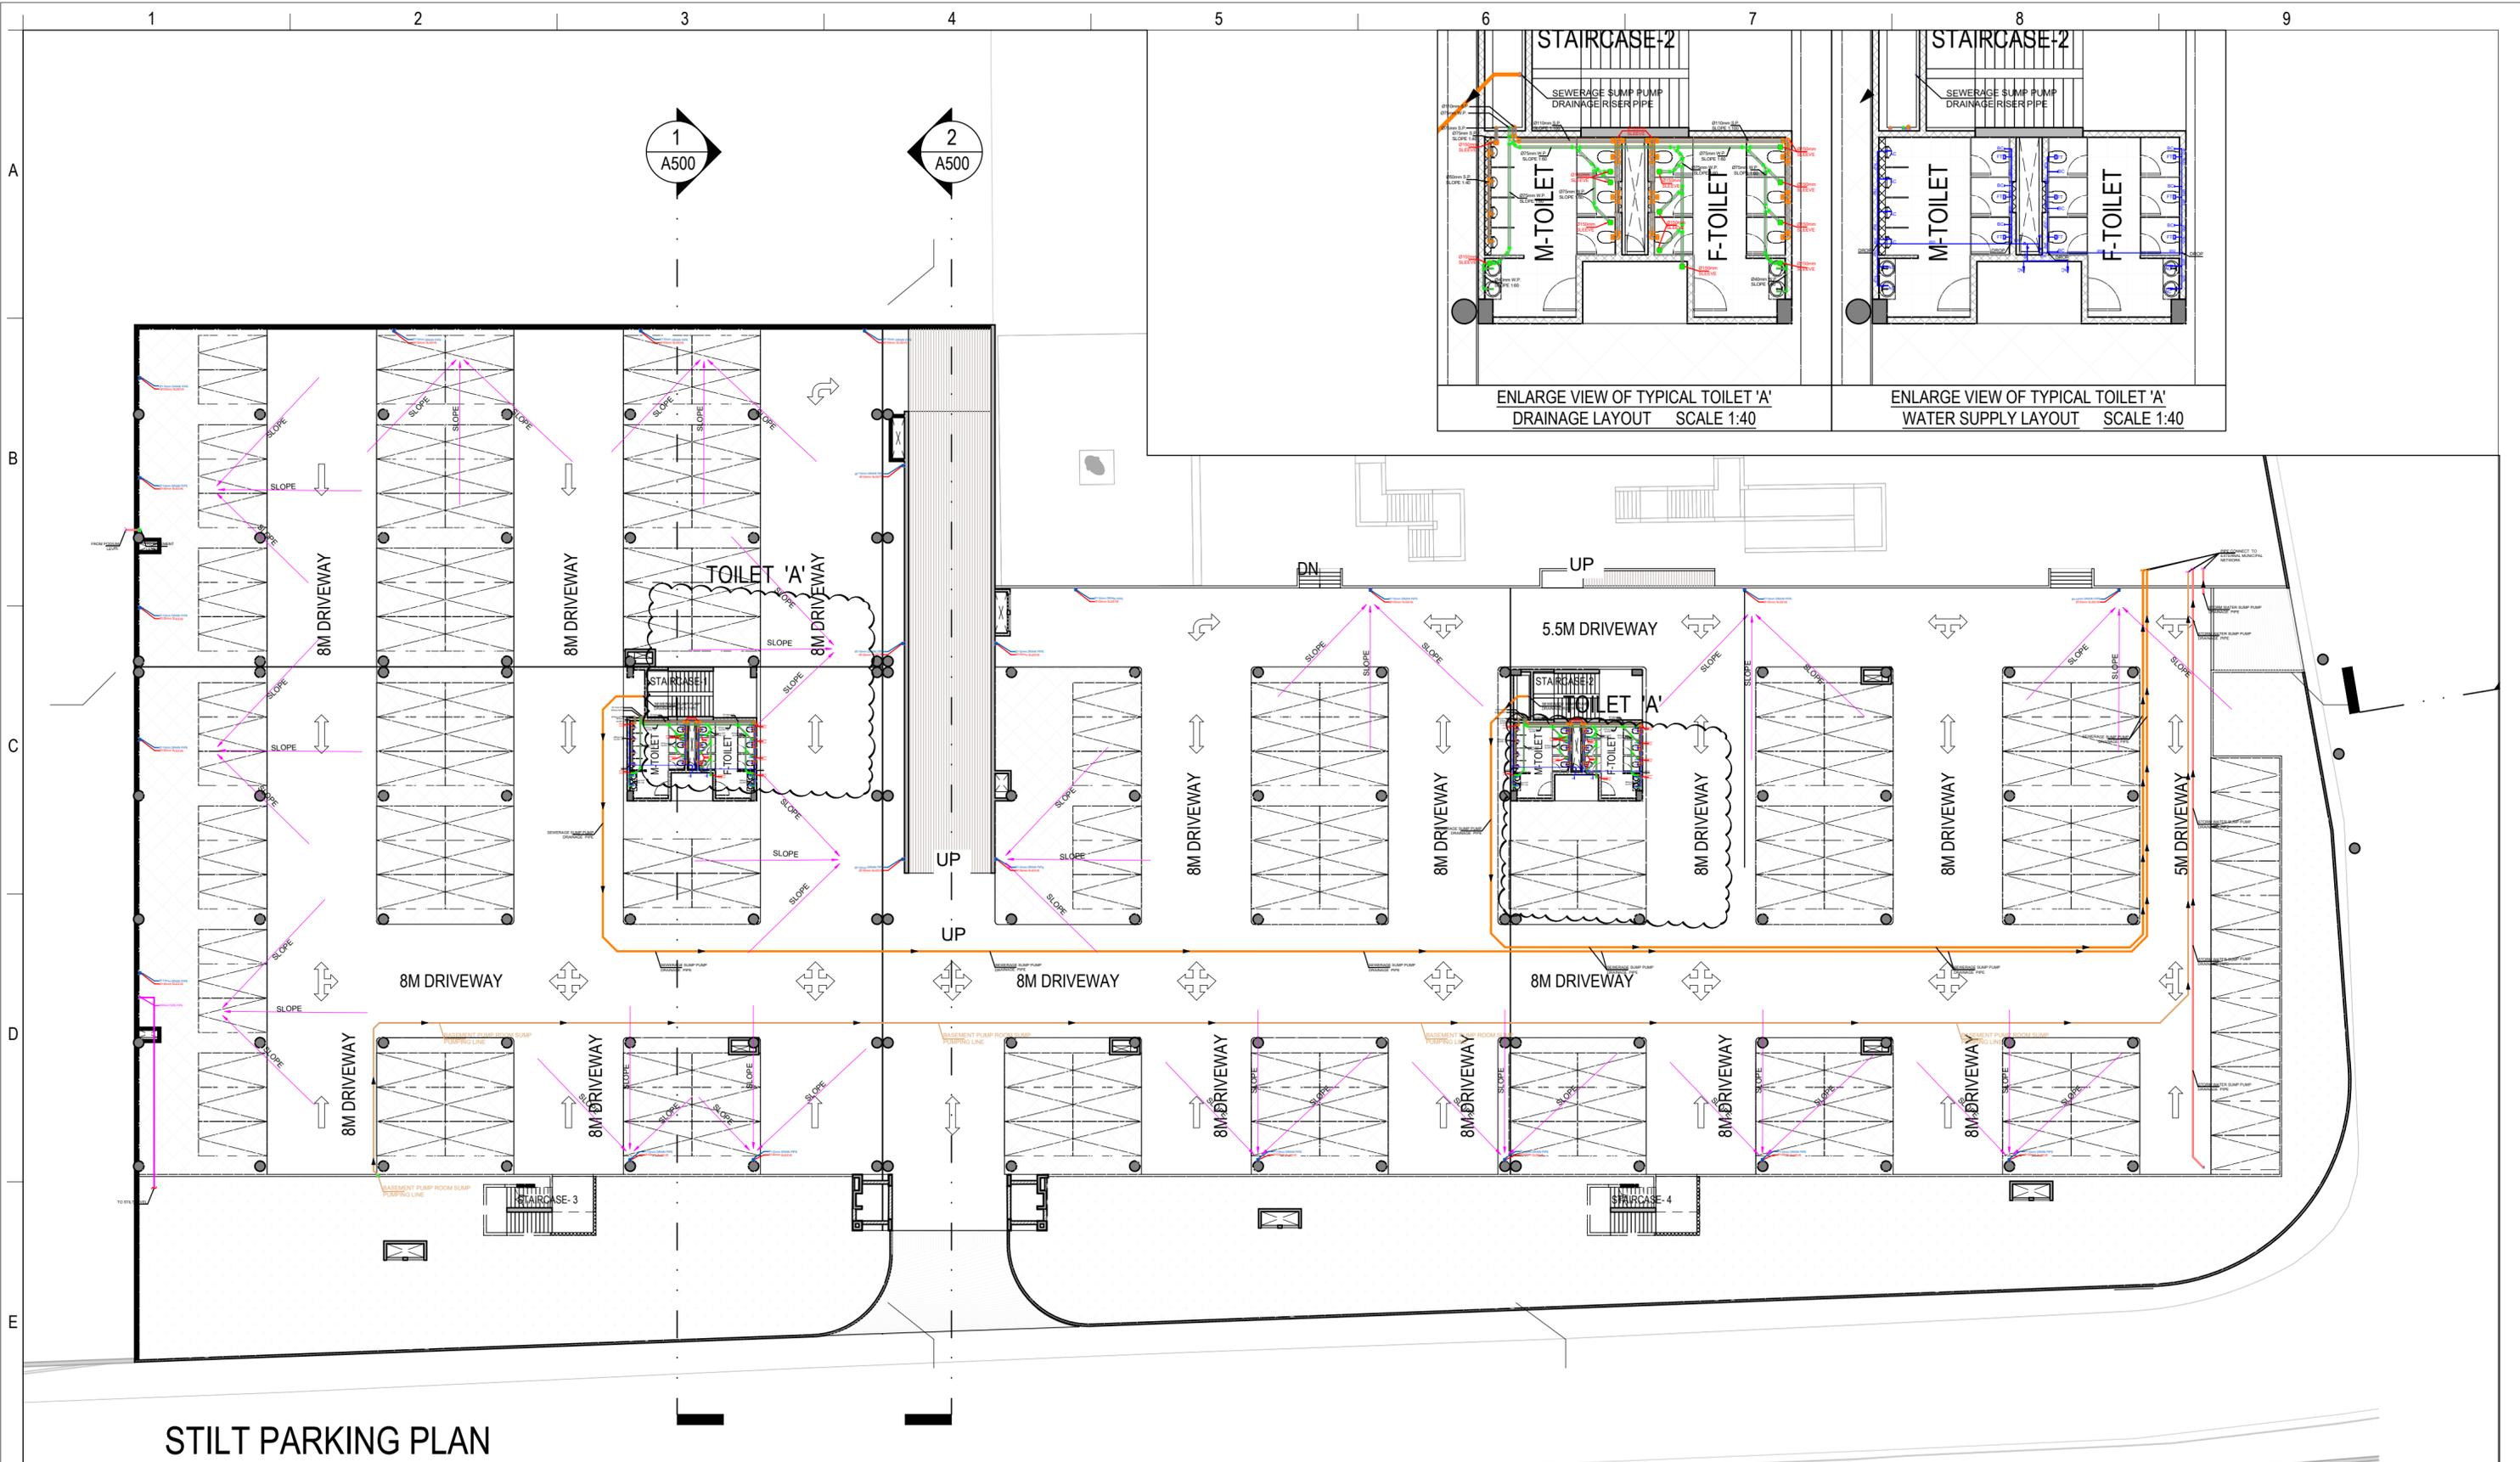

# STILT PARKING PLAN

**General Notes**

- DRAWINGS ARE THE COPYRIGHT PROPERTY OF INI DESIGN STUDIO. THE DRAWINGS AND SPECIFICATIONS FOR THIS PROJECT ARE PROTECTED BY COPYRIGHT AND WILL NOT BE REPRODUCED, USED, OR DISTRIBUTED WITHOUT EXPRESS WRITTEN PERMISSION OF INI DESIGN STUDIO.
- THESE DRAWINGS INDICATE IN GENERAL THE PROJECT IN TERMS OF BUILDING DESIGN CONCEPTS, THE DIMENSIONS OF THE BUILDINGS AND THE MAJOR BUILDING DESIGN ELEMENTS. AS INDICATED OR SPECIFIED, THE CONTRACTOR SHALL FINISH ALL ITEMS REQUIRED FOR THE PROPER EXECUTION AND COMPLETION OF THE WORKS. DECISIONS OF THE INI AS TO THE ITEMS OF WORK INCLUDED WITHIN THE DOCUMENT SHALL BE FINAL AND BINDING ON THE CONTRACTOR.
- ALL DIMENSIONS ARE IN MILLIMETERS, UNLESS OTHERWISE MENTIONED / SPECIFIED.
- DRAWINGS IN NO CASE SHALL BE SCALED AND ONLY WRITTEN DIMENSIONS SHALL BE FOLLOWED. LARGE SCALE DETAILS SHALL TAKE PRECEDENCE OVER SMALL SCALE DRAWINGS.
- PARTITIONS AND WALLS SHOWN CENTERED ON COLUMN CENTER OR FLUSH-FACED WITH STRUCTURAL COLUMNS ARE NOT DIMENSIONED.
- CONTRACTOR SHALL INFORM AND OBTAIN PERMISSION IN WRITING FROM THE INI BEFORE MAKING ANY DEVIATIONS FROM THE DRAWINGS.
- ITEMS OF WORK REQUIRED ON ONE DRAWING OR IN ONE SECTION OF THE SPECIFICATIONS HAVE THE SAME FORCE AND EFFECT AS IF REQUIRED IN ALL DRAWINGS, OR IN ALL SECTIONS OF THE SPECIFICATIONS.
- PLINTH LEVELS TO BE DECIDED ON SITE WITH REFERENCE TO LEVELS ON THE SITE IN CONSULTATION WITH BUILDING DESIGN DRAWINGS.
- FOR DOOR AND WINDOWS SCHEDULE REFER DRAWING NO. \_\_\_\_\_
- FOR ROOM FINISH SCHEDULE REFER DRAWING NO. \_\_\_\_\_
- RAIN WATER DRAIN PIPES OR SLEEVES THROUGH BEAMS AND CURBING TO BE INSTALLED WHILE CASTING AS PER THE POSITIONS SHOWN.
- FOR DIMENSIONS, LOCATIONS AND DETAILS OF ALL STRUCTURAL MEMBERS REFER STRUCTURAL DRAWINGS.
- DIMENSIONS ON ALL ELEVATIONS AND SECTIONS SHOWN ON BUILDING DESIGN DRAWINGS ARE SHOWN AS TOP OF UN-FINISHED FLOOR LEVEL UNLESS OTHERWISE MENTIONED.
- ALL DRAWINGS SHALL BE READ IN CONJUNCTION WITH ALL OTHER CONSULTANTS' DRAWINGS, TOGETHER WITH THE SPECIFICATIONS, DISCREPANCIES AND / OR AMBIGUITIES, IF ANY, SHALL BE BROUGHT TO THE NOTICE OF THE INI AND CLARIFICATIONS SHALL BE MADE PRIOR TO EXECUTION. SCPL'S DECISION IN THIS REGARD SHALL BE FINAL AND BINDING.
- THE CONTRACTOR SHALL COORDINATE ALL MECHANICAL FLOOR AND WALL SLEEVES AND SHAFTS IN CONCRETE SLABS AND WALLS WITH MECHANICAL, PLUMBING, FIRE PROTECTION, ELECTRICAL, STRUCTURAL AND BUILDING DESIGN DRAWINGS.
- NOTES APPEARING ON VARIOUS DRAWINGS FOR DIFFERENT SYSTEMS AND MATERIAL SHEET SHALL BE REVIEWED AND NOTES ON ANY ONE DRAWING SHALL BE APPLIED TO RELATED DRAWINGS AND DETAILS.

LEGEND:-	
	450mm wide STORM WATER DRAIN CHANNEL WITH GRATINGS SLOPE 1:300
	FLOW DIRECTION
	STORM DRAIN SUMP PUMPING LINE
	STORM DRAIN PIPE
	DRAIN LINE
	DRAIN PIPE
	PUMP ROOM SUMP PUMPING LINE
	PUMP ROOM SUMP PIPE
	SEWERAGE SUMP PUMP DRAINAGE PIPE
	SEWERAGE PIPE
	450x450mm CATCH BASIN
	DOMESTIC WATER SUPPLY
	FLUSH TANK
	BIB COCK WITH HEALTH FAUCET
	ANGLE COCK
	IRRIGATION WATER SUPPLY
	GARDEN HYDRANT
	WASTE PIPE
	SOIL PIPE
	SOIL STACK
	WASTE STACK
	N/NI TRAP
	FLOOR DRAIN

Rev	Purpose of Issue	Date	Authorized

TENDER DRAWINGS

Key Plan

Project :  
**SANSKAR KENDRA PLAZA**

Client :  
**SRFDCL**

Design Consultant :  
**INI DESIGN STUDIO**  
T/72, 1st Floor, Copernicus Road, Sakinaka, Ahmedabad 380015  
Phone: +91 79 44388071 / 72 / 22 www.inidesignstudio.com  
Email: info@inidesignstudio.com  
INI DESIGN STUDIO  
Ahmedabad | Mumbai | Pune | Kolkata


Structural Consultant :

Project :  
**INI Project no : 124200580**

Drawing Title : **PLUMBING LAYOUT FOR LOWER GROUND LEVEL PLAN**

Original Scale :  
Drawn By : **KK** | Checked By : **NT** | Authorized By : **NT** | Size : **A2**  
Date : 05.12.2025 | Date : 05.12.2025 | Date : 05.12.2025

Drawing Number : **PL-STI-01** | Rev :

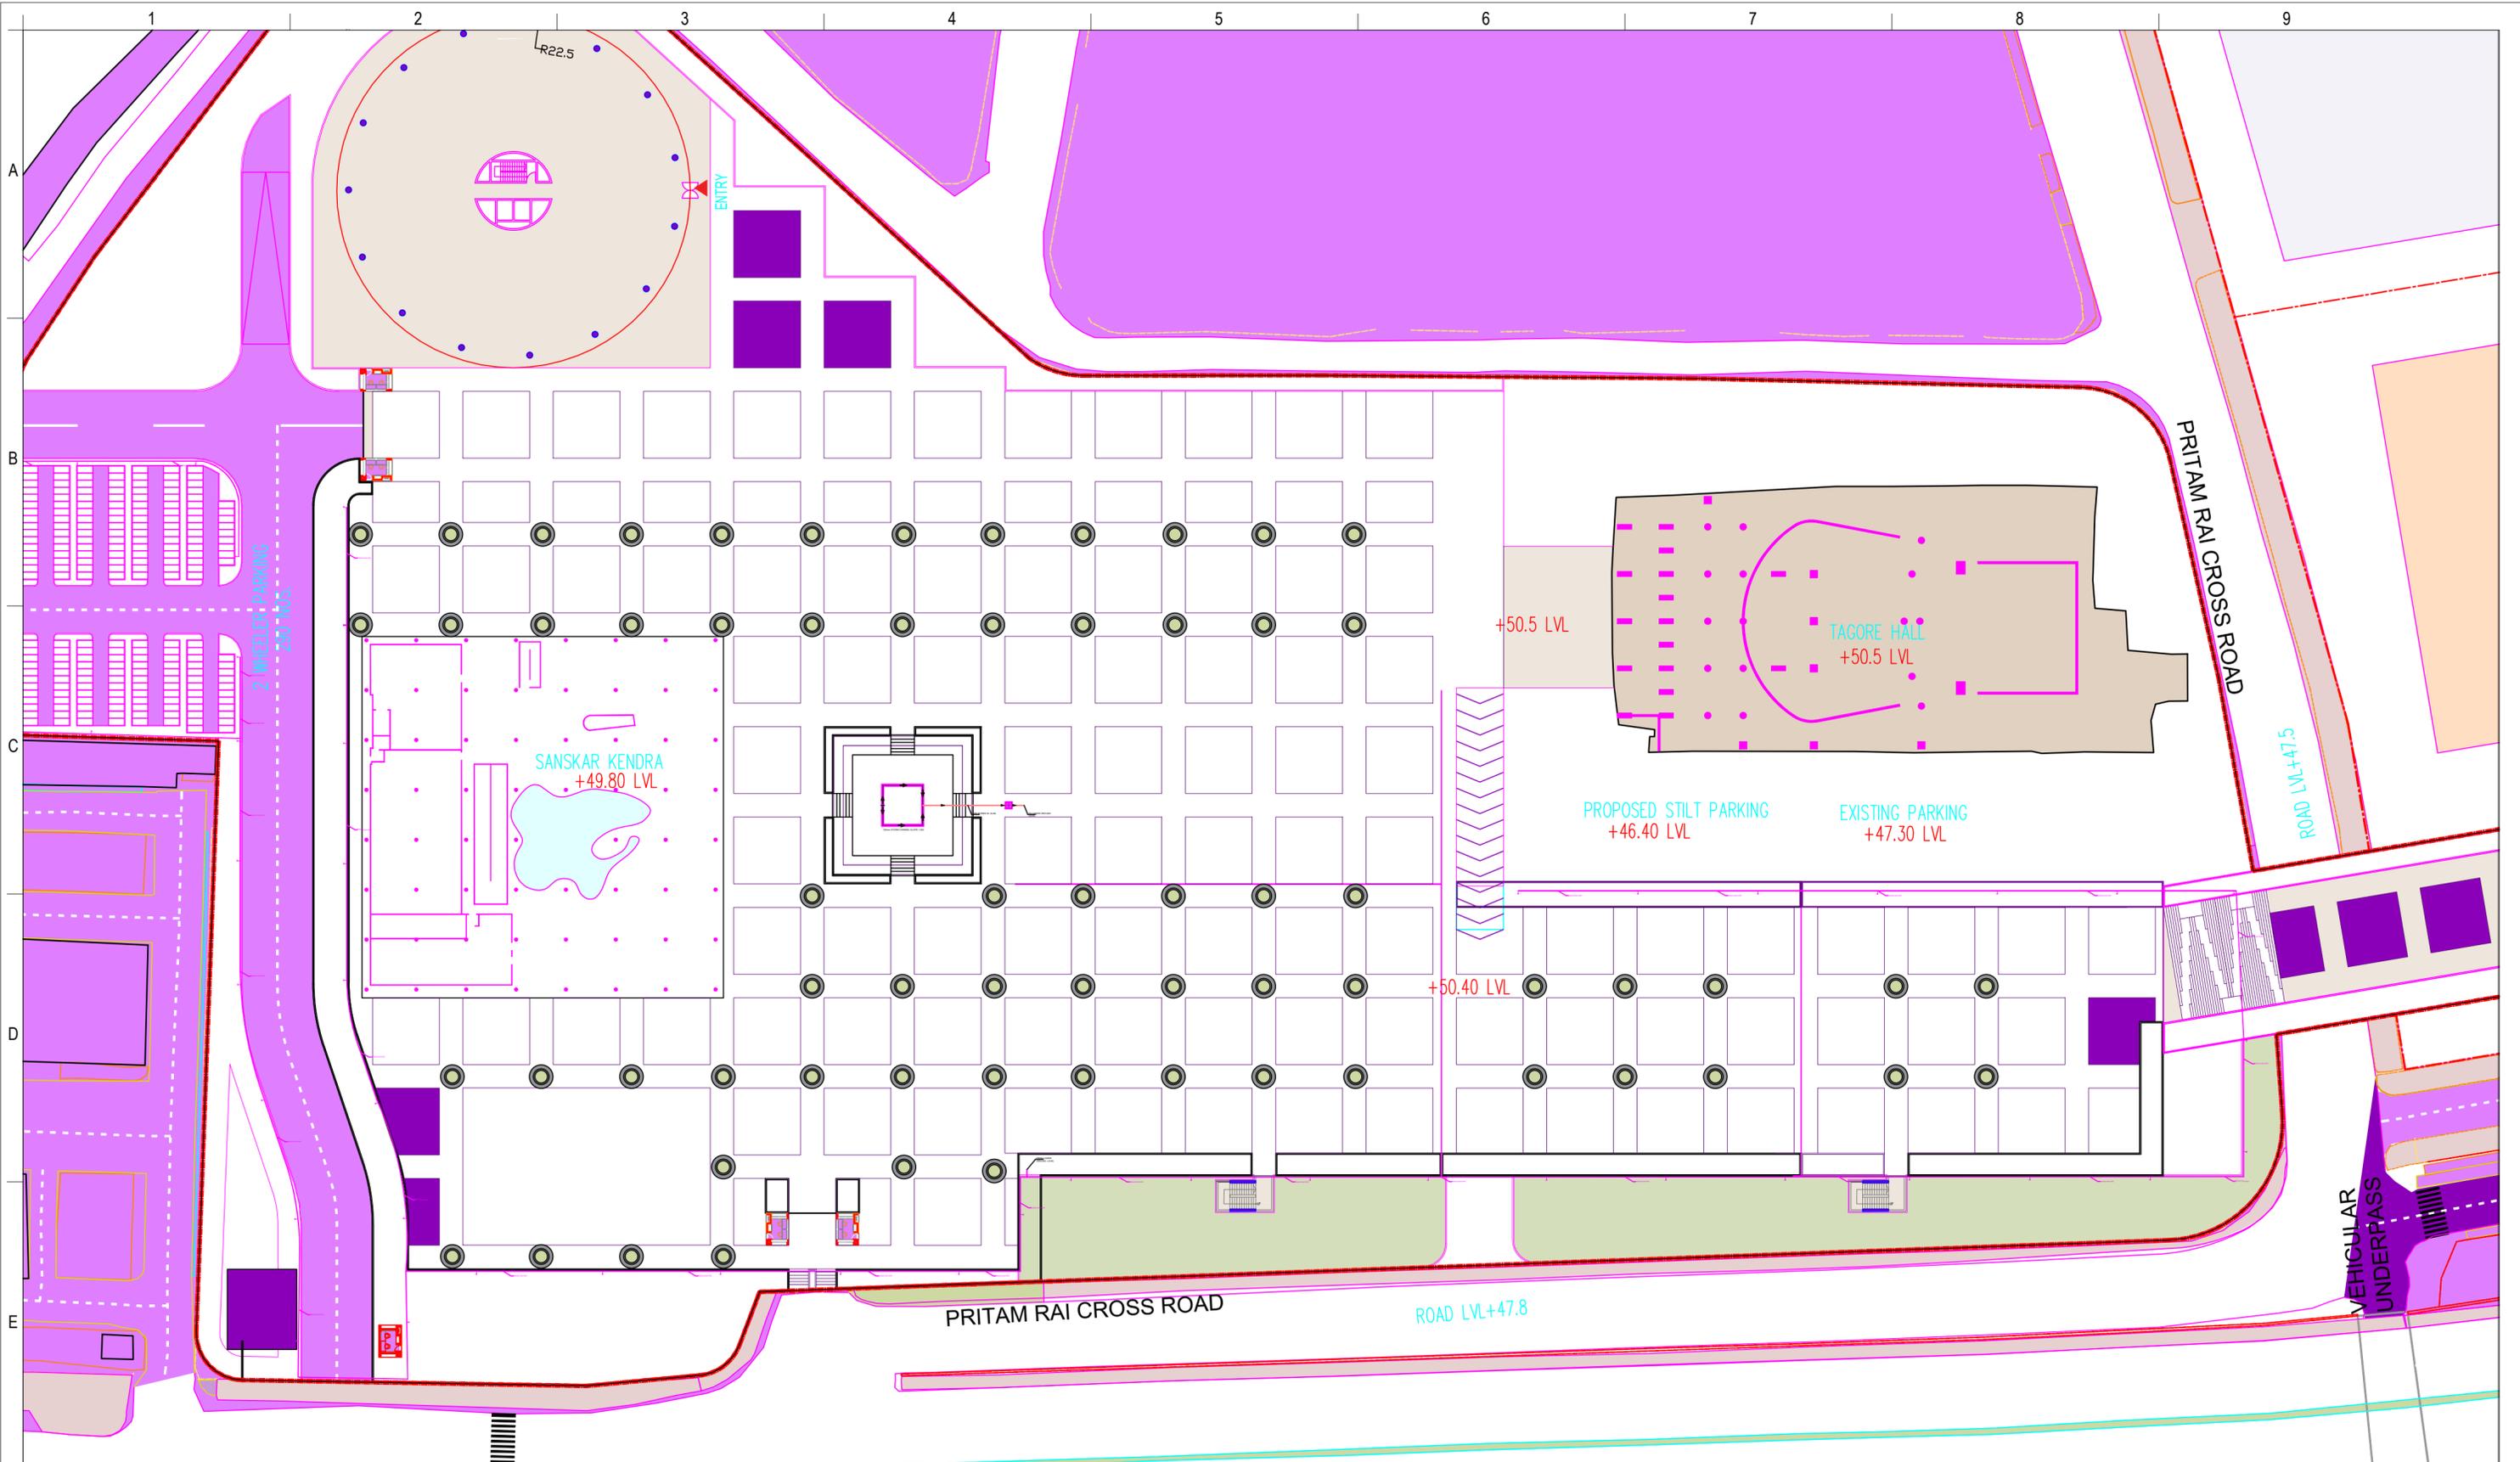

**General Notes**

- DRAWINGS ARE THE COPYRIGHT PROPERTY OF INI DESIGN STUDIO. THE DRAWINGS AND SPECIFICATIONS FOR THIS PROJECT ARE PROTECTED BY COPYRIGHT AND WILL NOT BE REPRODUCED, USED, OR DISTRIBUTED WITHOUT EXPRESS WRITTEN PERMISSION OF INI DESIGN STUDIO.
- THESE DRAWINGS INDICATE IN GENERAL THE PROJECT IN TERMS OF BUILDING DESIGN CONCEPTS, THE DIMENSIONS OF THE BUILDINGS AND THE MAJOR BUILDING DESIGN ELEMENTS. AS INDICATED OR SPECIFIED, THE CONTRACTOR SHALL FINISH ALL ITEMS REQUIRED FOR THE PROPER EXECUTION AND COMPLETION OF THE WORKS. DECISIONS OF THE INI AS TO THE ITEMS OF WORK INCLUDED WITHIN THE DOCUMENT SHALL BE FINAL AND BINDING ON THE CONTRACTOR.
- ALL DIMENSIONS ARE IN MILLIMETERS, UNLESS OTHERWISE MENTIONED / SPECIFIED.
- DRAWINGS IN NO CASE SHALL BE SCALED AND ONLY WRITTEN DIMENSIONS SHALL BE FOLLOWED. LARGE SCALE DETAILS SHALL TAKE PRECEDENCE OVER SMALL SCALE DRAWINGS.
- PARTITIONS AND WALLS SHOWN CENTERED ON COLUMN CENTER OR FLUSH-FACED WITH STRUCTURAL COLUMNS ARE NOT DIMENSIONED.
- CONTRACTOR SHALL INFORM AND OBTAIN PERMISSION IN WRITING FROM THE INI BEFORE MAKING ANY DEVIATIONS FROM THE DRAWINGS.
- ITEMS OF WORK REQUIRED ON ONE DRAWING OR IN ONE SECTION OF THE SPECIFICATIONS HAVE THE SAME FORCE AND EFFECT AS IF REQUIRED IN ALL DRAWINGS, OR IN ALL SECTIONS.
- PLINTH LEVELS TO BE DECIDED ON SITE WITH REFERENCE TO LEVELS ON THE SITE IN CONSULTATION WITH BUILDING DESIGN DRAWINGS.
- FOR DOOR AND WINDOWS SCHEDULE REFER DRAWING NO. \_\_\_\_\_
- FOR ROOM FINISH SCHEDULE REFER DRAWING NO. \_\_\_\_\_
- RAIN WATER DRAIN PIPES OR SLEEVES THROUGH BEAMS AND CURBING TO BE INSTALLED WHILE CASTING AS PER THE POSITIONS SHOWN.
- FOR DIMENSIONS, LOCATIONS AND DETAILS OF ALL STRUCTURAL MEMBERS REFER STRUCTURAL DRAWINGS.
- DIMENSIONS ON ALL ELEVATIONS AND SECTIONS SHOWN ON BUILDING DESIGN DRAWINGS ARE SHOWN AS TOP OF UN-FINISHED FLOOR LEVEL UNLESS OTHERWISE MENTIONED.
- ALL DRAWINGS SHALL BE READ IN CONJUNCTION WITH ALL OTHER CONSULTANTS' DRAWINGS, TOGETHER WITH THE SPECIFICATIONS, DISCREPANCIES AND / OR AMBIGUITIES, IF ANY, SHALL BE BROUGHT TO THE NOTICE OF THE INI AND CLARIFICATIONS SHALL BE MADE PRIOR TO EXECUTION. SCPL'S DECISION IN THIS REGARD SHALL BE FINAL AND BINDING.
- THE CONTRACTOR SHALL COORDINATE ALL MECHANICAL FLOOR AND WALL SLEEVES AND SHAFTS IN CONCRETE SLABS AND WALLS WITH MECHANICAL, PLUMBING, FIRE PROTECTION, ELECTRICAL, STRUCTURAL AND BUILDING DESIGN DRAWINGS.
- NOTES APPEARING ON VARIOUS DRAWINGS FOR DIFFERENT SYSTEMS AND MATERIAL SHEET SHALL BE REVIEWED AND NOTES ON ANY ONE DRAWING SHALL BE APPLIED TO RELATED DRAWINGS AND DETAILS.

LEGEND:-	
	DOMESTIC WATER SUPPLY
	FLUSH TANK
	BBB COCK WITH HEALTH FAUCET
	TABLE VALVE
	ANGLE COCK
	IRRIGATION WATER SUPPLY
	GARDEN HYDRANT
	WASTE PIPE
	SOIL PIPE
	SOIL STACK
	WASTE STACK
	NT NAHNI TRAP
	FD FLOOR DRAIN

Rev	Purpose of Issue	Date	Authorized

**TENDER DRAWINGS**

Key Plan


Project :  
**SANSKAR KENDRA PLAZA**

Client :  
**SRFDCL**

Design Consultant :  
**INI DESIGN STUDIO**  
INI DESIGN STUDIO  
T/72, 1st Floor, Copernicus Road, Sakinaka, Ahmedabad-380015  
Phone: +91 79 44388070 | T/11, 2nd Floor, 1st Floor, Sakinaka  
Email: info@inidesignstudio.com | www.inidesignstudio.com  
Design, MEP Engineering, Interior, Landscape, Interior Design, P&ID, Health Planning, Urban & Regional Planning, Rehabilitation & Renewal

Structural Consultant :

Project :	SRFDCL		
Project :	INI Project no : 124200580		
Drawing Title :	PLUMBING LAYOUT FOR PODIUM LEVEL PLAN		
Original Scale :	Drawn By : <b>KK</b>	Checked By : <b>NT</b>	Authorized By : <b>NT</b>
	Date : 05.12.2025	Date : 05.12.2025	Date : 05.12.2025
Drawing Number :	PL-POD-01		
Size :	A2		
Rev :			

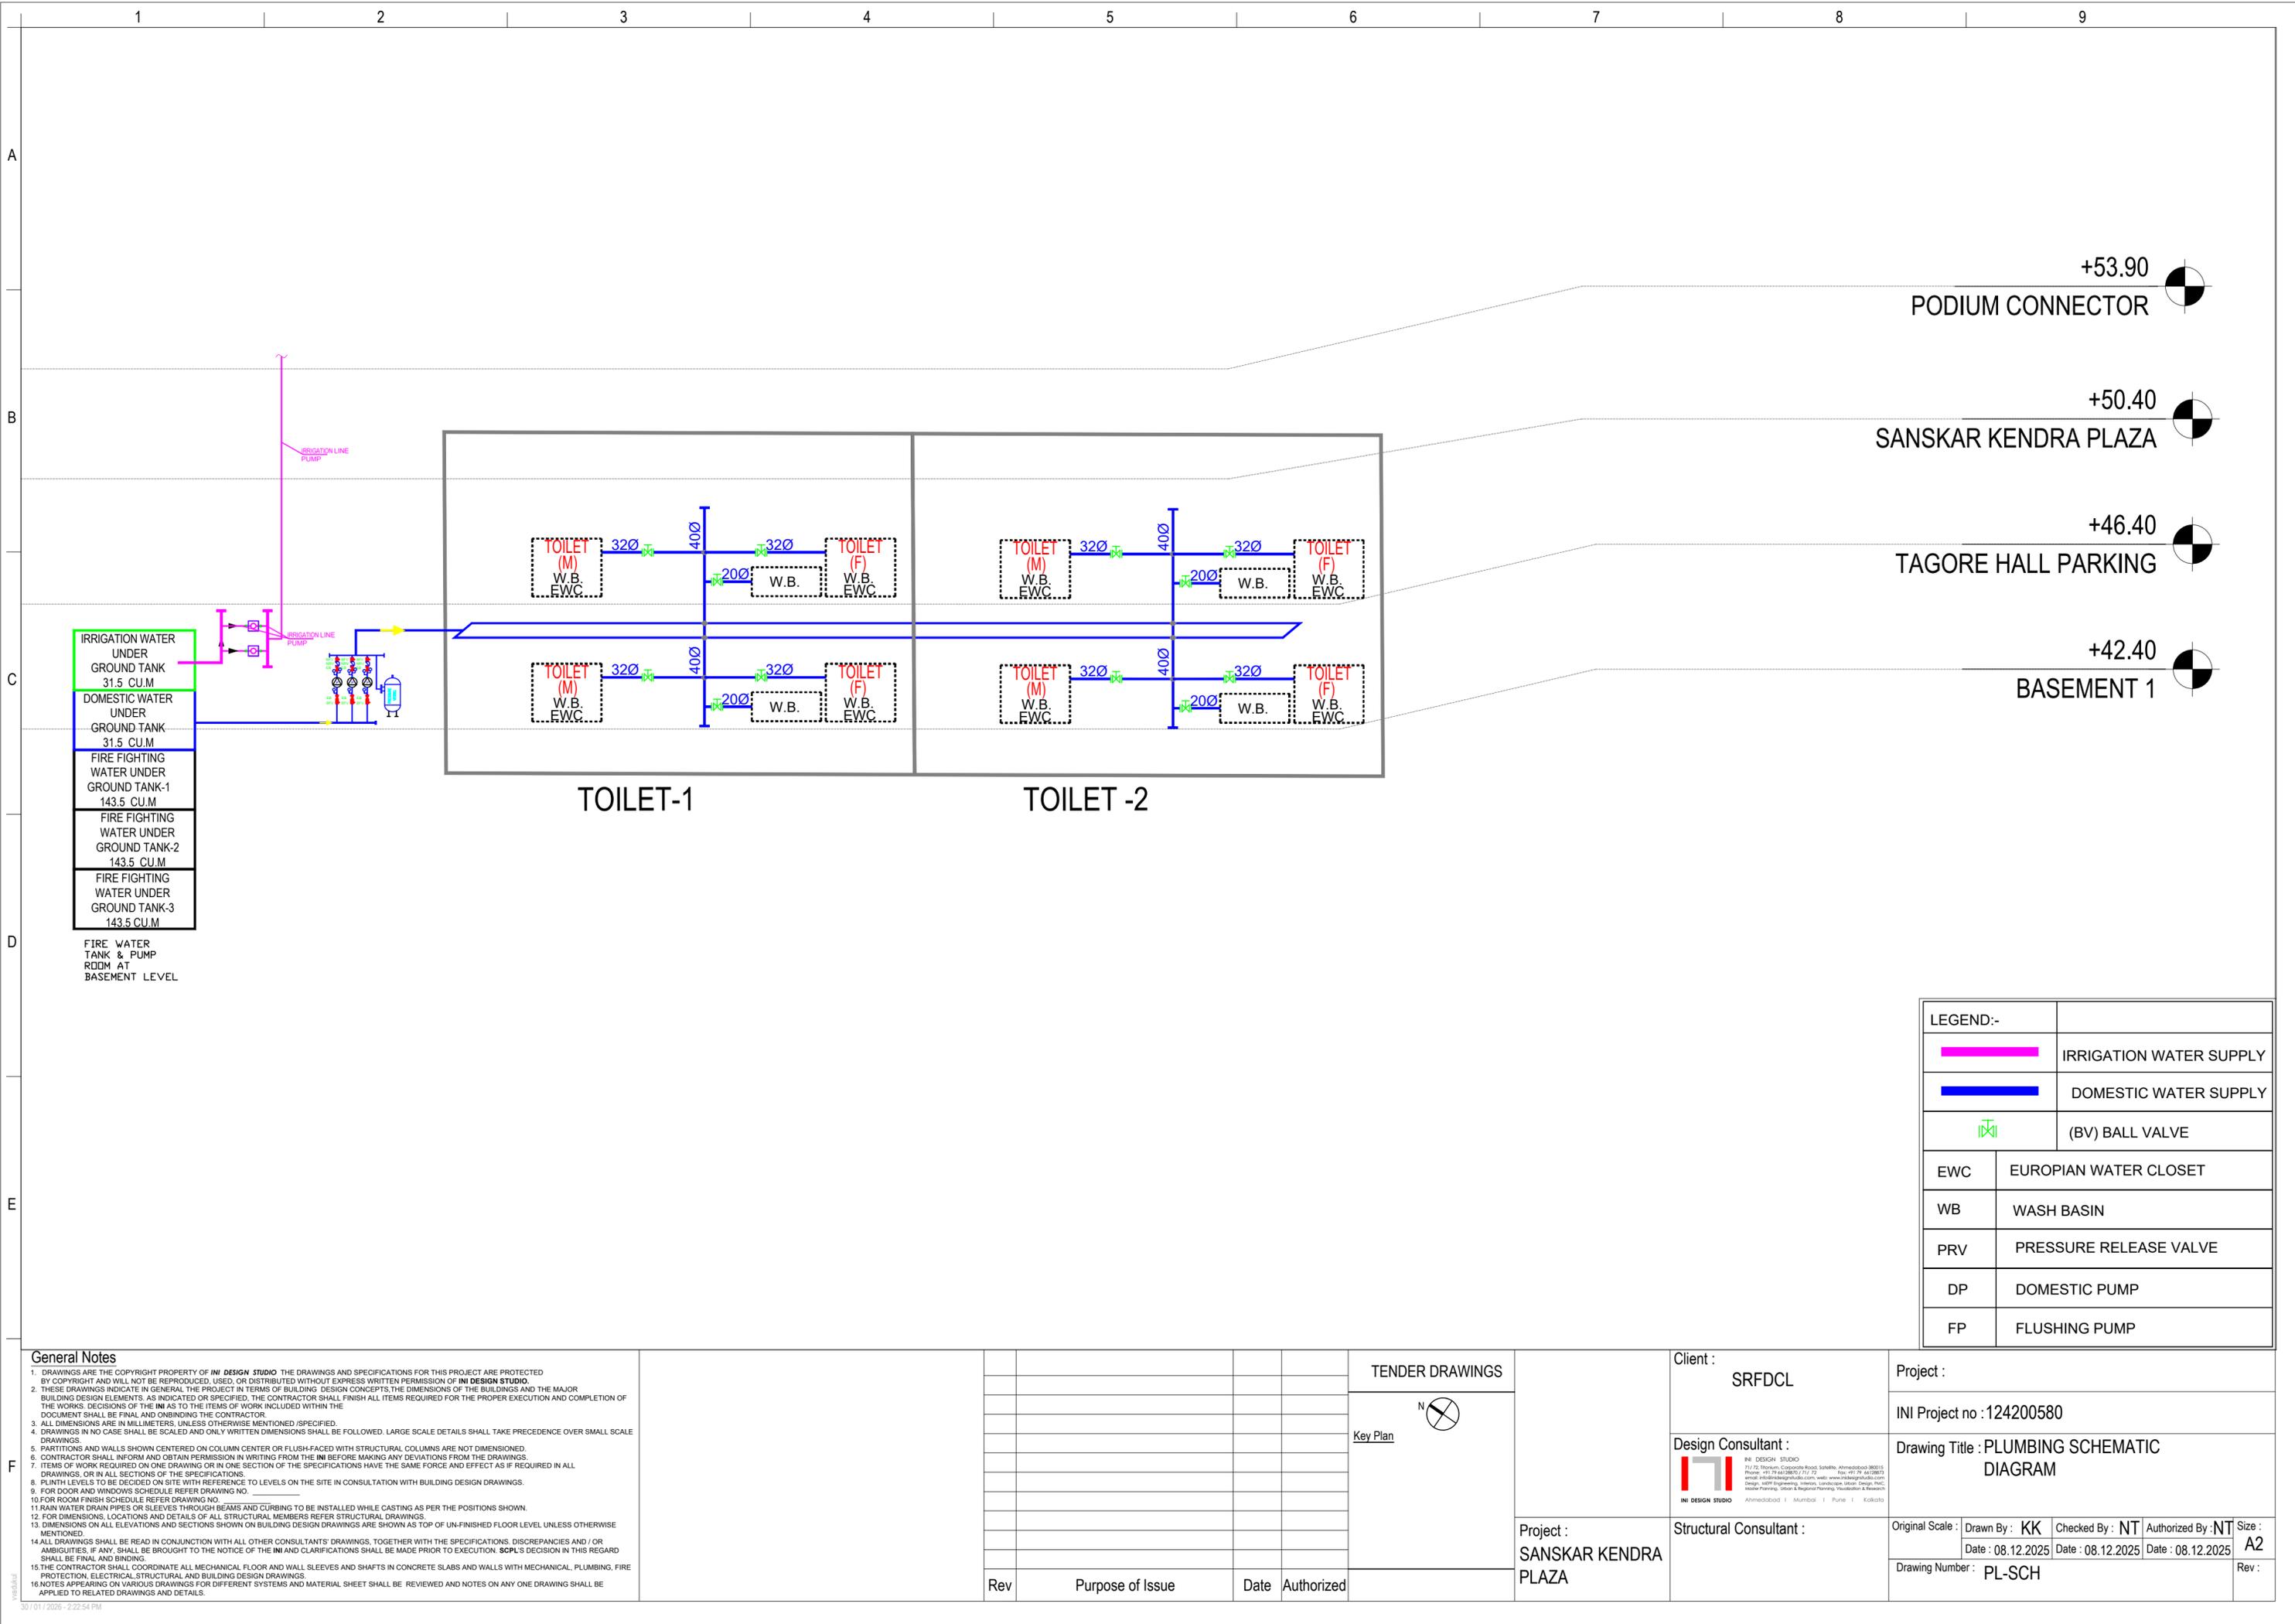

+53.90

PODIUM CONNECTOR

+50.40

SANSKAR KENDRA PLAZA

+46.40


TAGORE HALL PARKING

+42.40

BASEMENT 1

TOILET-1

TOILET-2

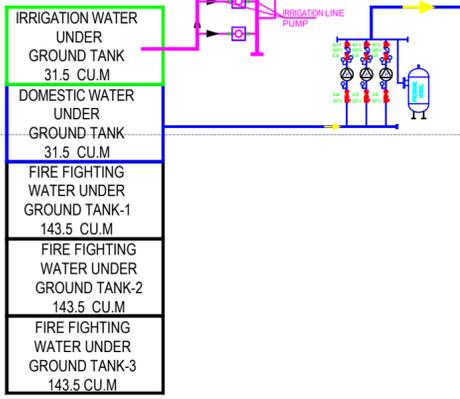

FIRE WATER TANK & PUMP ROOM AT BASEMENT LEVEL

LEGEND:-	
	IRRIGATION WATER SUPPLY
	DOMESTIC WATER SUPPLY
	(BV) BALL VALVE
EWC	EUROPIAN WATER CLOSET
WB	WASH BASIN
PRV	PRESSURE RELEASE VALVE
DP	DOMESTIC PUMP
FP	FLUSHING PUMP

**General Notes**

- DRAWINGS ARE THE COPYRIGHT PROPERTY OF INI DESIGN STUDIO. THE DRAWINGS AND SPECIFICATIONS FOR THIS PROJECT ARE PROTECTED BY COPYRIGHT AND WILL NOT BE REPRODUCED, USED, OR DISTRIBUTED WITHOUT EXPRESS WRITTEN PERMISSION OF INI DESIGN STUDIO.
- THESE DRAWINGS INDICATE IN GENERAL THE PROJECT IN TERMS OF BUILDING DESIGN CONCEPTS, THE DIMENSIONS OF THE BUILDINGS AND THE MAJOR BUILDING DESIGN ELEMENTS. AS INDICATED OR SPECIFIED, THE CONTRACTOR SHALL FINISH ALL ITEMS REQUIRED FOR THE PROPER EXECUTION AND COMPLETION OF THE WORKS. DECISIONS OF THE INI AS TO THE ITEMS OF WORK INCLUDED WITHIN THE DOCUMENT SHALL BE FINAL AND BINDING ON THE CONTRACTOR.
- ALL DIMENSIONS ARE IN MILLIMETERS, UNLESS OTHERWISE MENTIONED /SPECIFIED.
- DRAWINGS IN NO CASE SHALL BE SCALED AND ONLY WRITTEN DIMENSIONS SHALL BE FOLLOWED. LARGE SCALE DETAILS SHALL TAKE PRECEDENCE OVER SMALL SCALE DRAWINGS.
- PARTITIONS AND WALLS SHOWN CENTERED ON COLUMN CENTER OR FLUSH-FACED WITH STRUCTURAL COLUMNS ARE NOT DIMENSIONED.
- CONTRACTOR SHALL INFORM AND OBTAIN PERMISSION IN WRITING FROM THE INI BEFORE MAKING ANY DEVIATIONS FROM THE DRAWINGS.
- ITEMS OF WORK REQUIRED ON ONE DRAWING OR IN ONE SECTION OF THE SPECIFICATIONS HAVE THE SAME FORCE AND EFFECT AS IF REQUIRED IN ALL DRAWINGS, OR IN ALL SECTIONS OF THE SPECIFICATIONS.
- PLINTH LEVELS TO BE DECIDED ON SITE WITH REFERENCE TO LEVELS ON THE SITE IN CONSULTATION WITH BUILDING DESIGN DRAWINGS.
- FOR DOOR AND WINDOWS SCHEDULE REFER DRAWING NO. \_\_\_\_\_
- FOR ROOM FINISH SCHEDULE REFER DRAWING NO. \_\_\_\_\_
- RAIN WATER DRAIN PIPES OR SLEEVES THROUGH BEAMS AND CURBING TO BE INSTALLED WHILE CASTING AS PER THE POSITIONS SHOWN.
- FOR DIMENSIONS, LOCATIONS AND DETAILS OF ALL STRUCTURAL MEMBERS REFER STRUCTURAL DRAWINGS.
- DIMENSIONS ON ALL ELEVATIONS AND SECTIONS SHOWN ON BUILDING DESIGN DRAWINGS ARE SHOWN AS TOP OF UN-FINISHED FLOOR LEVEL UNLESS OTHERWISE MENTIONED.
- ALL DRAWINGS SHALL BE READ IN CONJUNCTION WITH ALL OTHER CONSULTANTS' DRAWINGS, TOGETHER WITH THE SPECIFICATIONS, DISCREPANCIES AND / OR AMBIGUITIES, IF ANY, SHALL BE BROUGHT TO THE NOTICE OF THE INI AND CLARIFICATIONS SHALL BE MADE PRIOR TO EXECUTION. SCPL'S DECISION IN THIS REGARD SHALL BE FINAL AND BINDING.
- THE CONTRACTOR SHALL COORDINATE ALL MECHANICAL FLOOR AND WALL SLEEVES AND SHAFTS IN CONCRETE SLABS AND WALLS WITH MECHANICAL, PLUMBING, FIRE PROTECTION, ELECTRICAL, STRUCTURAL AND BUILDING DESIGN DRAWINGS.
- NOTES APPEARING ON VARIOUS DRAWINGS FOR DIFFERENT SYSTEMS AND MATERIAL SHEET SHALL BE REVIEWED AND NOTES ON ANY ONE DRAWING SHALL BE APPLIED TO RELATED DRAWINGS AND DETAILS.

Rev	Purpose of Issue	Date	Authorized

TENDER DRAWINGS

Key Plan

Project : SANSKAR KENDRA PLAZA

Client : SRFDCL

Design Consultant : INI DESIGN STUDIO

Structural Consultant :

Project : INI Project no : 124200580

Drawing Title : PLUMBING SCHEMATIC DIAGRAM

Original Scale :	Drawn By : KK	Checked By : NT	Authorized By : NT	Size : A2
	Date : 08.12.2025	Date : 08.12.2025	Date : 08.12.2025	
Drawing Number : PL-SCH				Rev :